





GROUND FLOOR PLUMBING PLAN
SCALE: 1/8" = 1'-0"

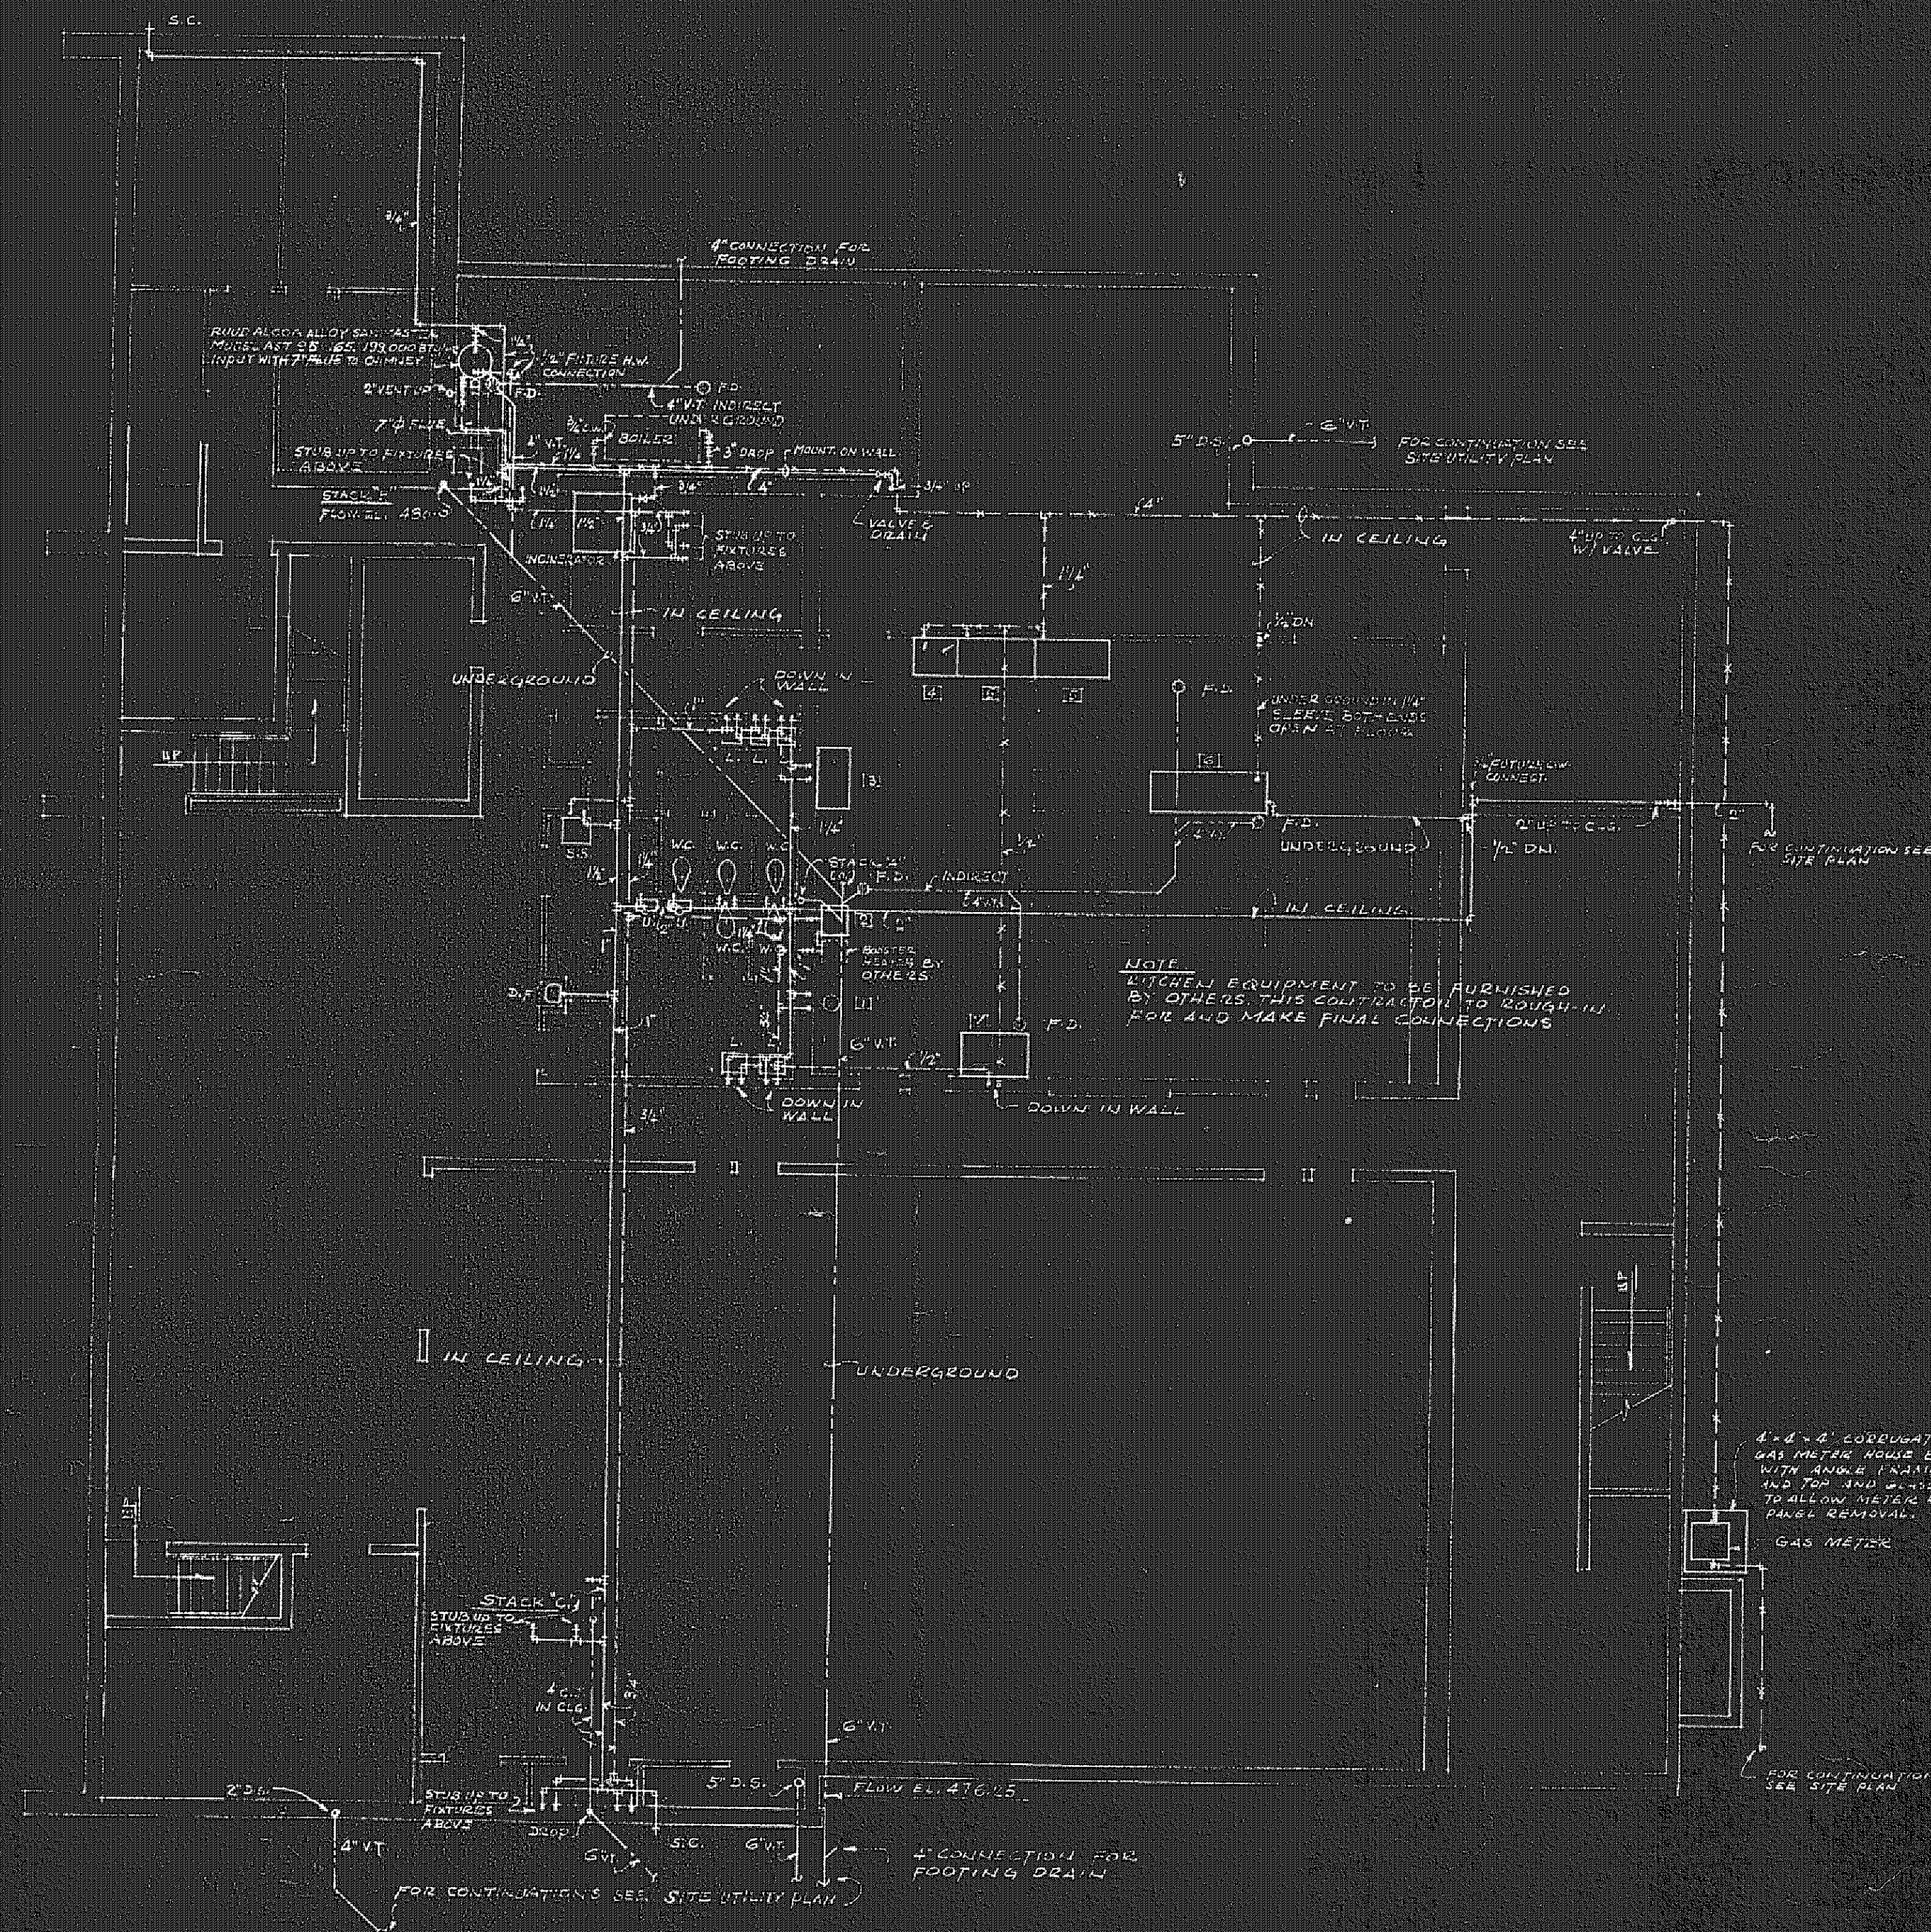

STACK A

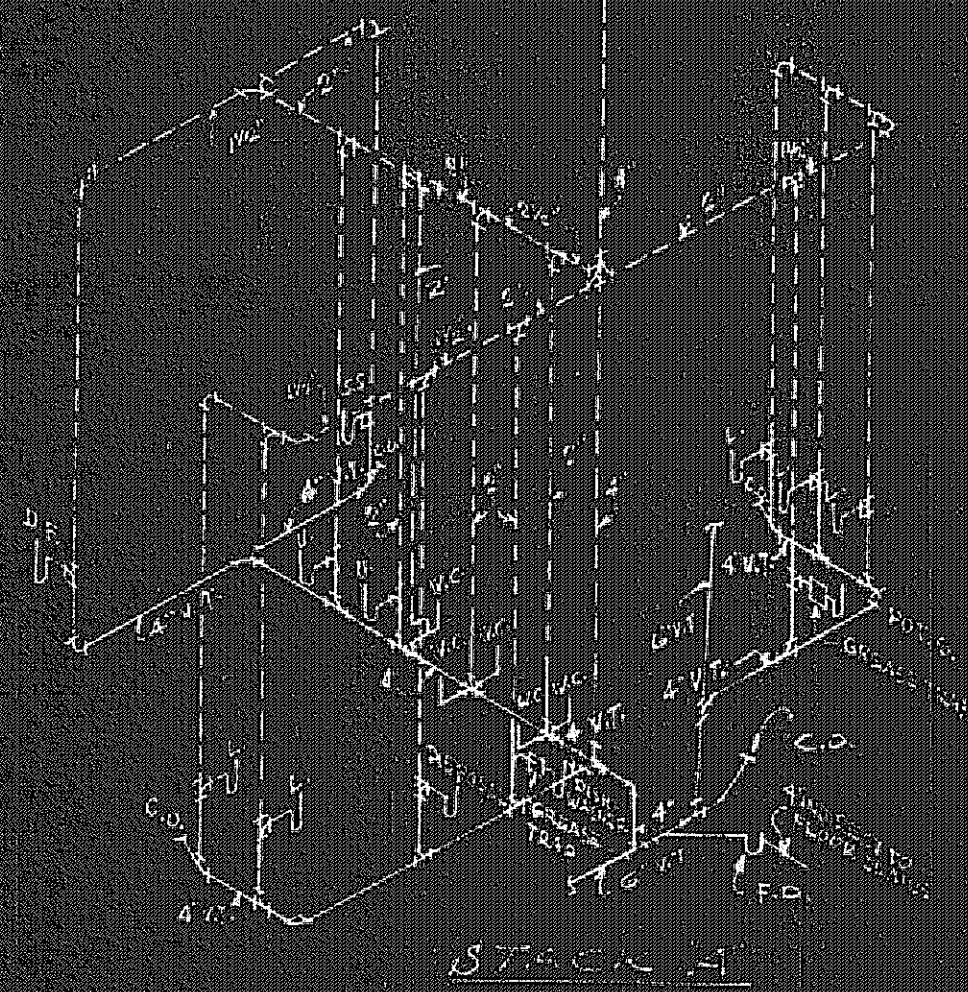

STACK B



STACK C

LEGEND

W.C.	WATER CLOSET
S.S.	SINK
F.D.	FLOOR DRAIN
D.S.	DOWN SINK
C.O.	CLEAN OUT
C.B.	CATCH BASIN
C.S.	CATCH SINK
V.C.	VENT

COLD WATER (C.W.) LINE
HOT WATER (H.W.) LINE
GAS LINE
DRAINAGE SEWER
STRAIN SEWER
WATER CLOSET
URINAL
SINK
SINK
DOWN SINK
DRAINAGE SEWER
BILL COCK
FLOOR DRAIN
DOWN SINK
CLEAN OUT
CATCH BASIN
CATCH SINK
WATER CLOSET

NOTES

BRANCH PIPING TO EACH FIXTURE SHALL BE SIZED AS NOTED IN THE FOLLOWING TABLE:

FIXTURE	C.W.	H.W.	VENT	GAS
W.C.	1/2"	1/2"	2"	1/2"
S.S.	3/4"	3/4"	2"	1/2"
F.D.	1/2"	1/2"	1 1/2"	1/2"
D.S.	1/2"	1/2"	2"	1/2"
C.O.	3/4"	3/4"	2"	1/2"
C.B.	1/2"	1/2"	1 1/2"	1/2"

KITCHEN EQUIPMENT

MARK	DESCRIPTION	C.W.	H.W.	VENT	GAS
1	DISHWASHER	1/2"	1/2"	2"	1/2"
2	DISHWASHER	1/2"	1/2"	2"	1/2"
3	POT SINK	1/2"	1/2"	2"	1/2"
4	BAKERS OVEN	1/2"	1/2"	2"	1/2"
5	RANGE	1/2"	1/2"	2"	1/2"
6	STEAM TABLE	1/2"	1/2"	2"	1/2"
7	COFFEE POT	1/2"	1/2"	2"	1/2"

NOTE: KITCHEN EQUIPMENT TO BE FURNISHED BY OTHERS, INSTALLED BY THIS CONTRACTOR.

